

## **LEGEND**

PROPOSED CONCRETE

PROPOSED SOD

PROPOSED DETECTABLE WARNING STRIP

PROPOSED CARLYLE STREETLIGHT

PARKING COUNTS

**EXISTING** 24 SPACES


PROPOSED 18 SPACES



COBRA LIGHT (TYPICAL)



CARLYLE LIGHT (TYPICAL)

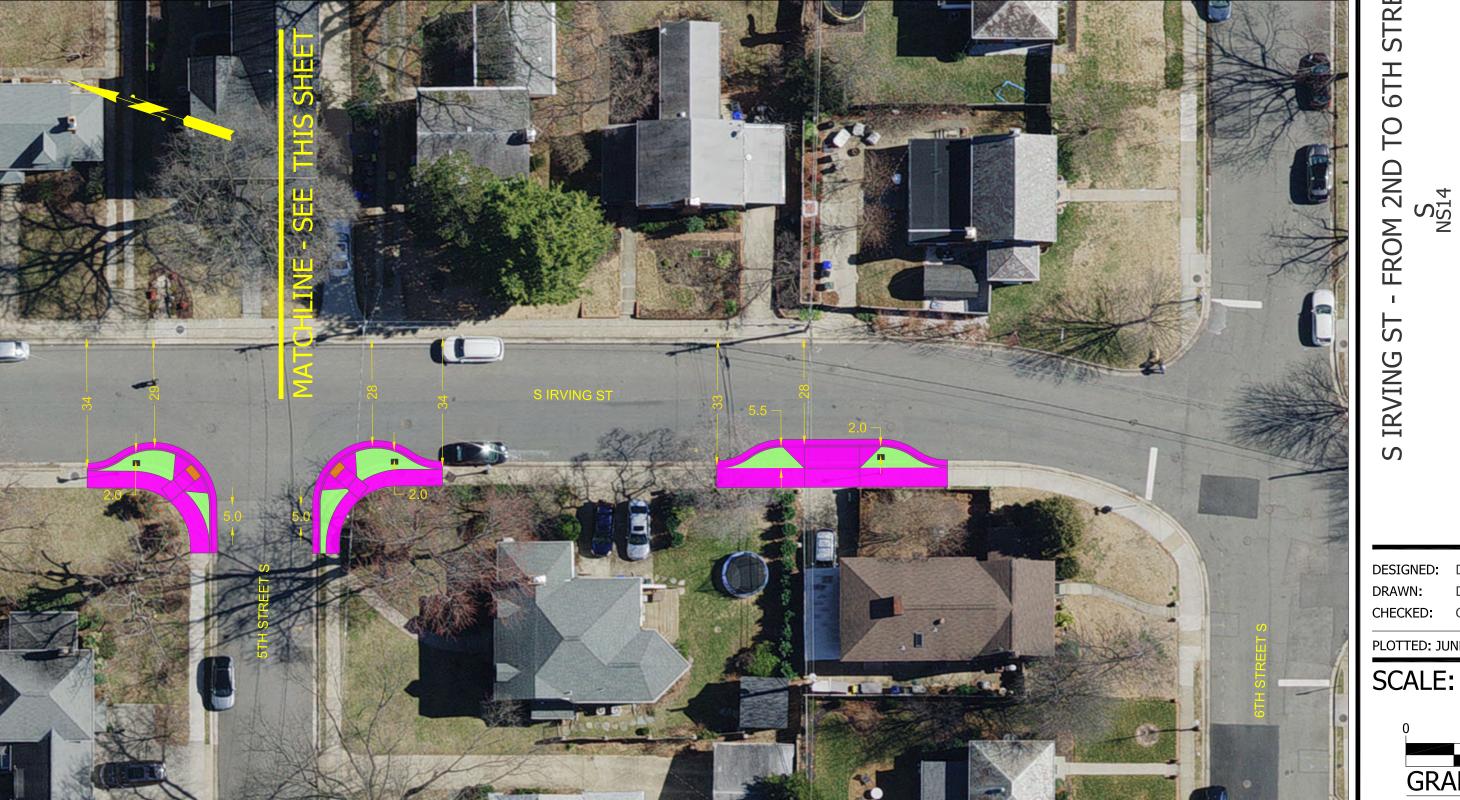

**ARLINGTON** VIRGINIA

**DEPARTMENT OF ENVIRONMENTAL SERVICES** FACILITIES & ENGINEERING DIVISION ENGINEERING BUREAU 2100 CLARENDON BOULEVARD, SUITE 813 ARLINGTON, VA 22201 PHONE: 703.228.3629 FAX: 703.228.3606

COPYRIGHT © 2023 ARLINGTON COUNTY VIRGINIA - ALL RIGHTS RESERVED

APPROVALS

QUALITY CONTROL ENGINEER

CONSTRUCTION MANAGEMENT SUPERVISOR

WATER, SEWER, STREETS BUREAU CHIEF

TRANSPORTATION DIRECTOR

PROJECT MANAGER

**REVISIONS** 

PLAN AND PROFILE

DESIGNED: DG DRAWN: DG CHECKED: GS

PLOTTED: JUNE 22 2023

GRAPHIC SCALE

C041.1